


PV Framework 1  
Scale 1:100

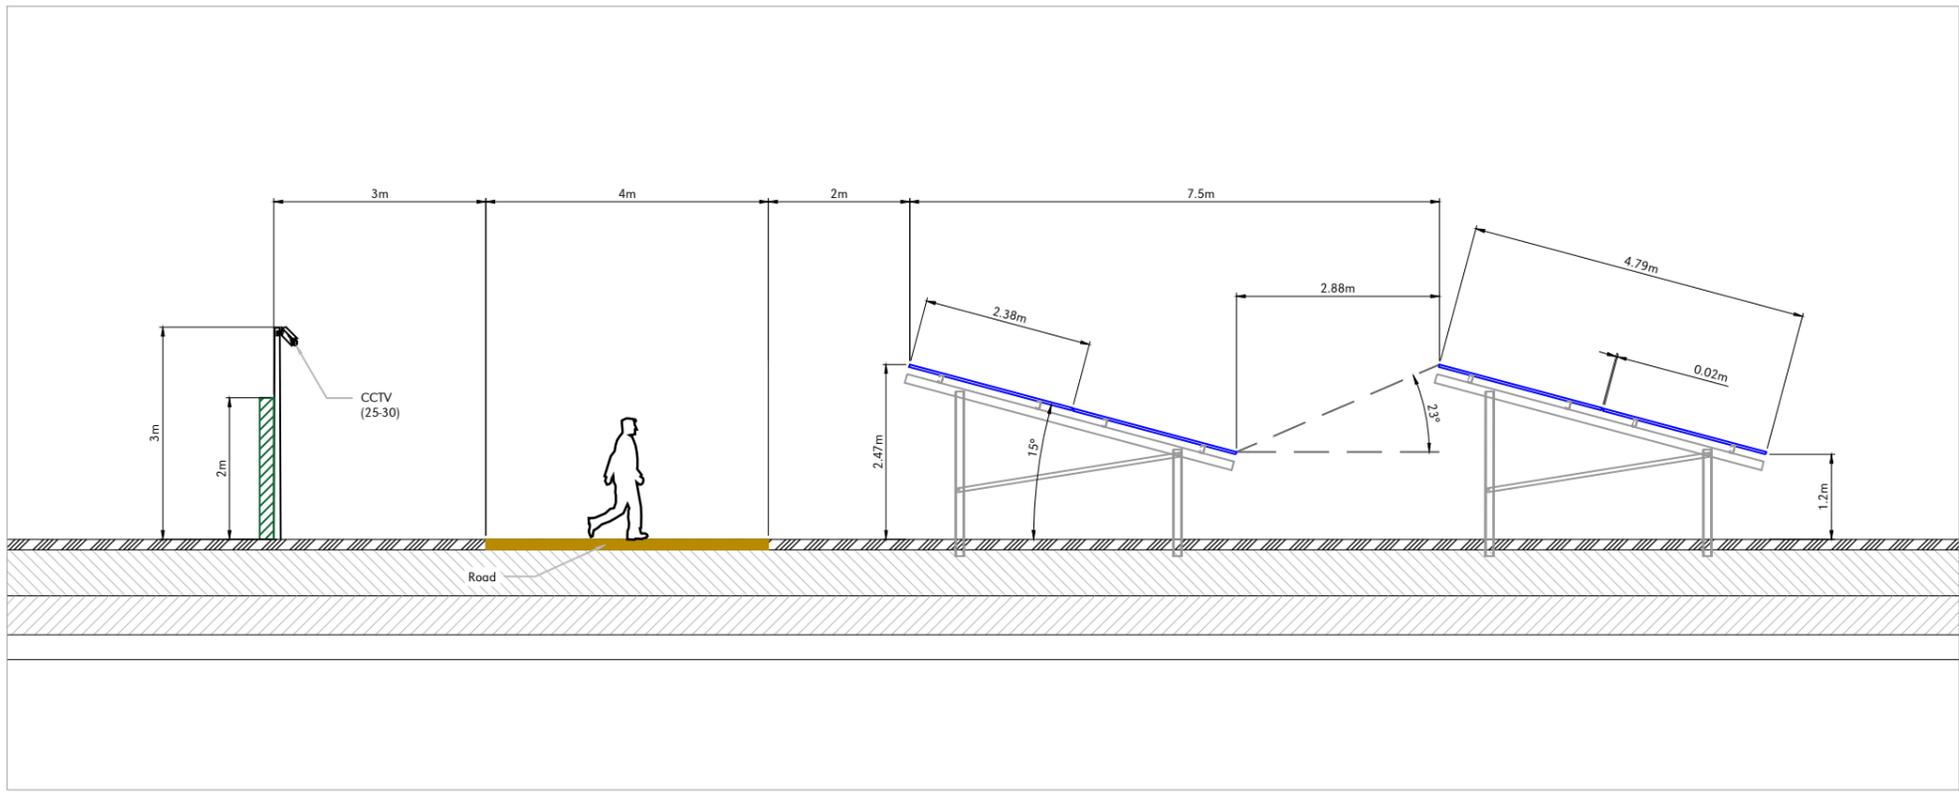

PV Framework 2  
Scale 1:100

- GENERAL NOTES:**
1. All dimensions noted are in meters unless stated otherwise.
  2. All levels to be above Ordnance Survey Datum defined levels (A.O.Dm) unless noted otherwise.
  3. Do not scale from this drawing, if dimensions are not clear ask.
  4. This document has been created in accordance with Plandescil Ltd. Terms & Conditions along with the scope of works provided by the client to Plandescil Ltd. Any use of this document other than for its original purpose is prohibited, Plandescil Ltd. accept no liability for any third party uses of this document.
  5. Plandescil Ltd. to be immediately notified of any suspected omissions or discrepancies.
  6. This drawing is to be read in conjunction with all other relevant documents relating to the project.
  7. Please refer to received drawing: SCUKX-MARDN-001-116 (20220308) CCTV Layout

**ISSUED FOR CLIENT REVIEW**

Rev	Date	Rev By	Chkd	Description
A	20-05-22	RJG	OAJ	Minor Amendments
0	25-03-22	-	OAJ	First Issue

**plandescil**  
consulting engineers

 
Connaught Road Attleborough Norfolk NR17 2BW  
Telephone: (01953) 452001 Fax: (01953) 456955  
E-mail: pdc@plandescil.co.uk www.plandescil.co.uk

civil / structural / environmental / surveying

Client  
**Origin Power Services Ltd.**

Project  
**Proposed Solar Farm,  
Land North of Sheephurst  
Lane, Marden, Tonbridge**

Drawing Title  
**PV Strucutre Framework**



Scale	U.N.O.	Date	Drawn By
As Noted (A3)		March 2022	RJG
Drawing No.	27899/105		Rev
			A

This drawing and the works depicted thereon are the copyright of Plandescil Consulting Engineers Ltd. Unauthorised reproduction infringes copyright.